
VETERANS HIGHWAY (S.R. 413)

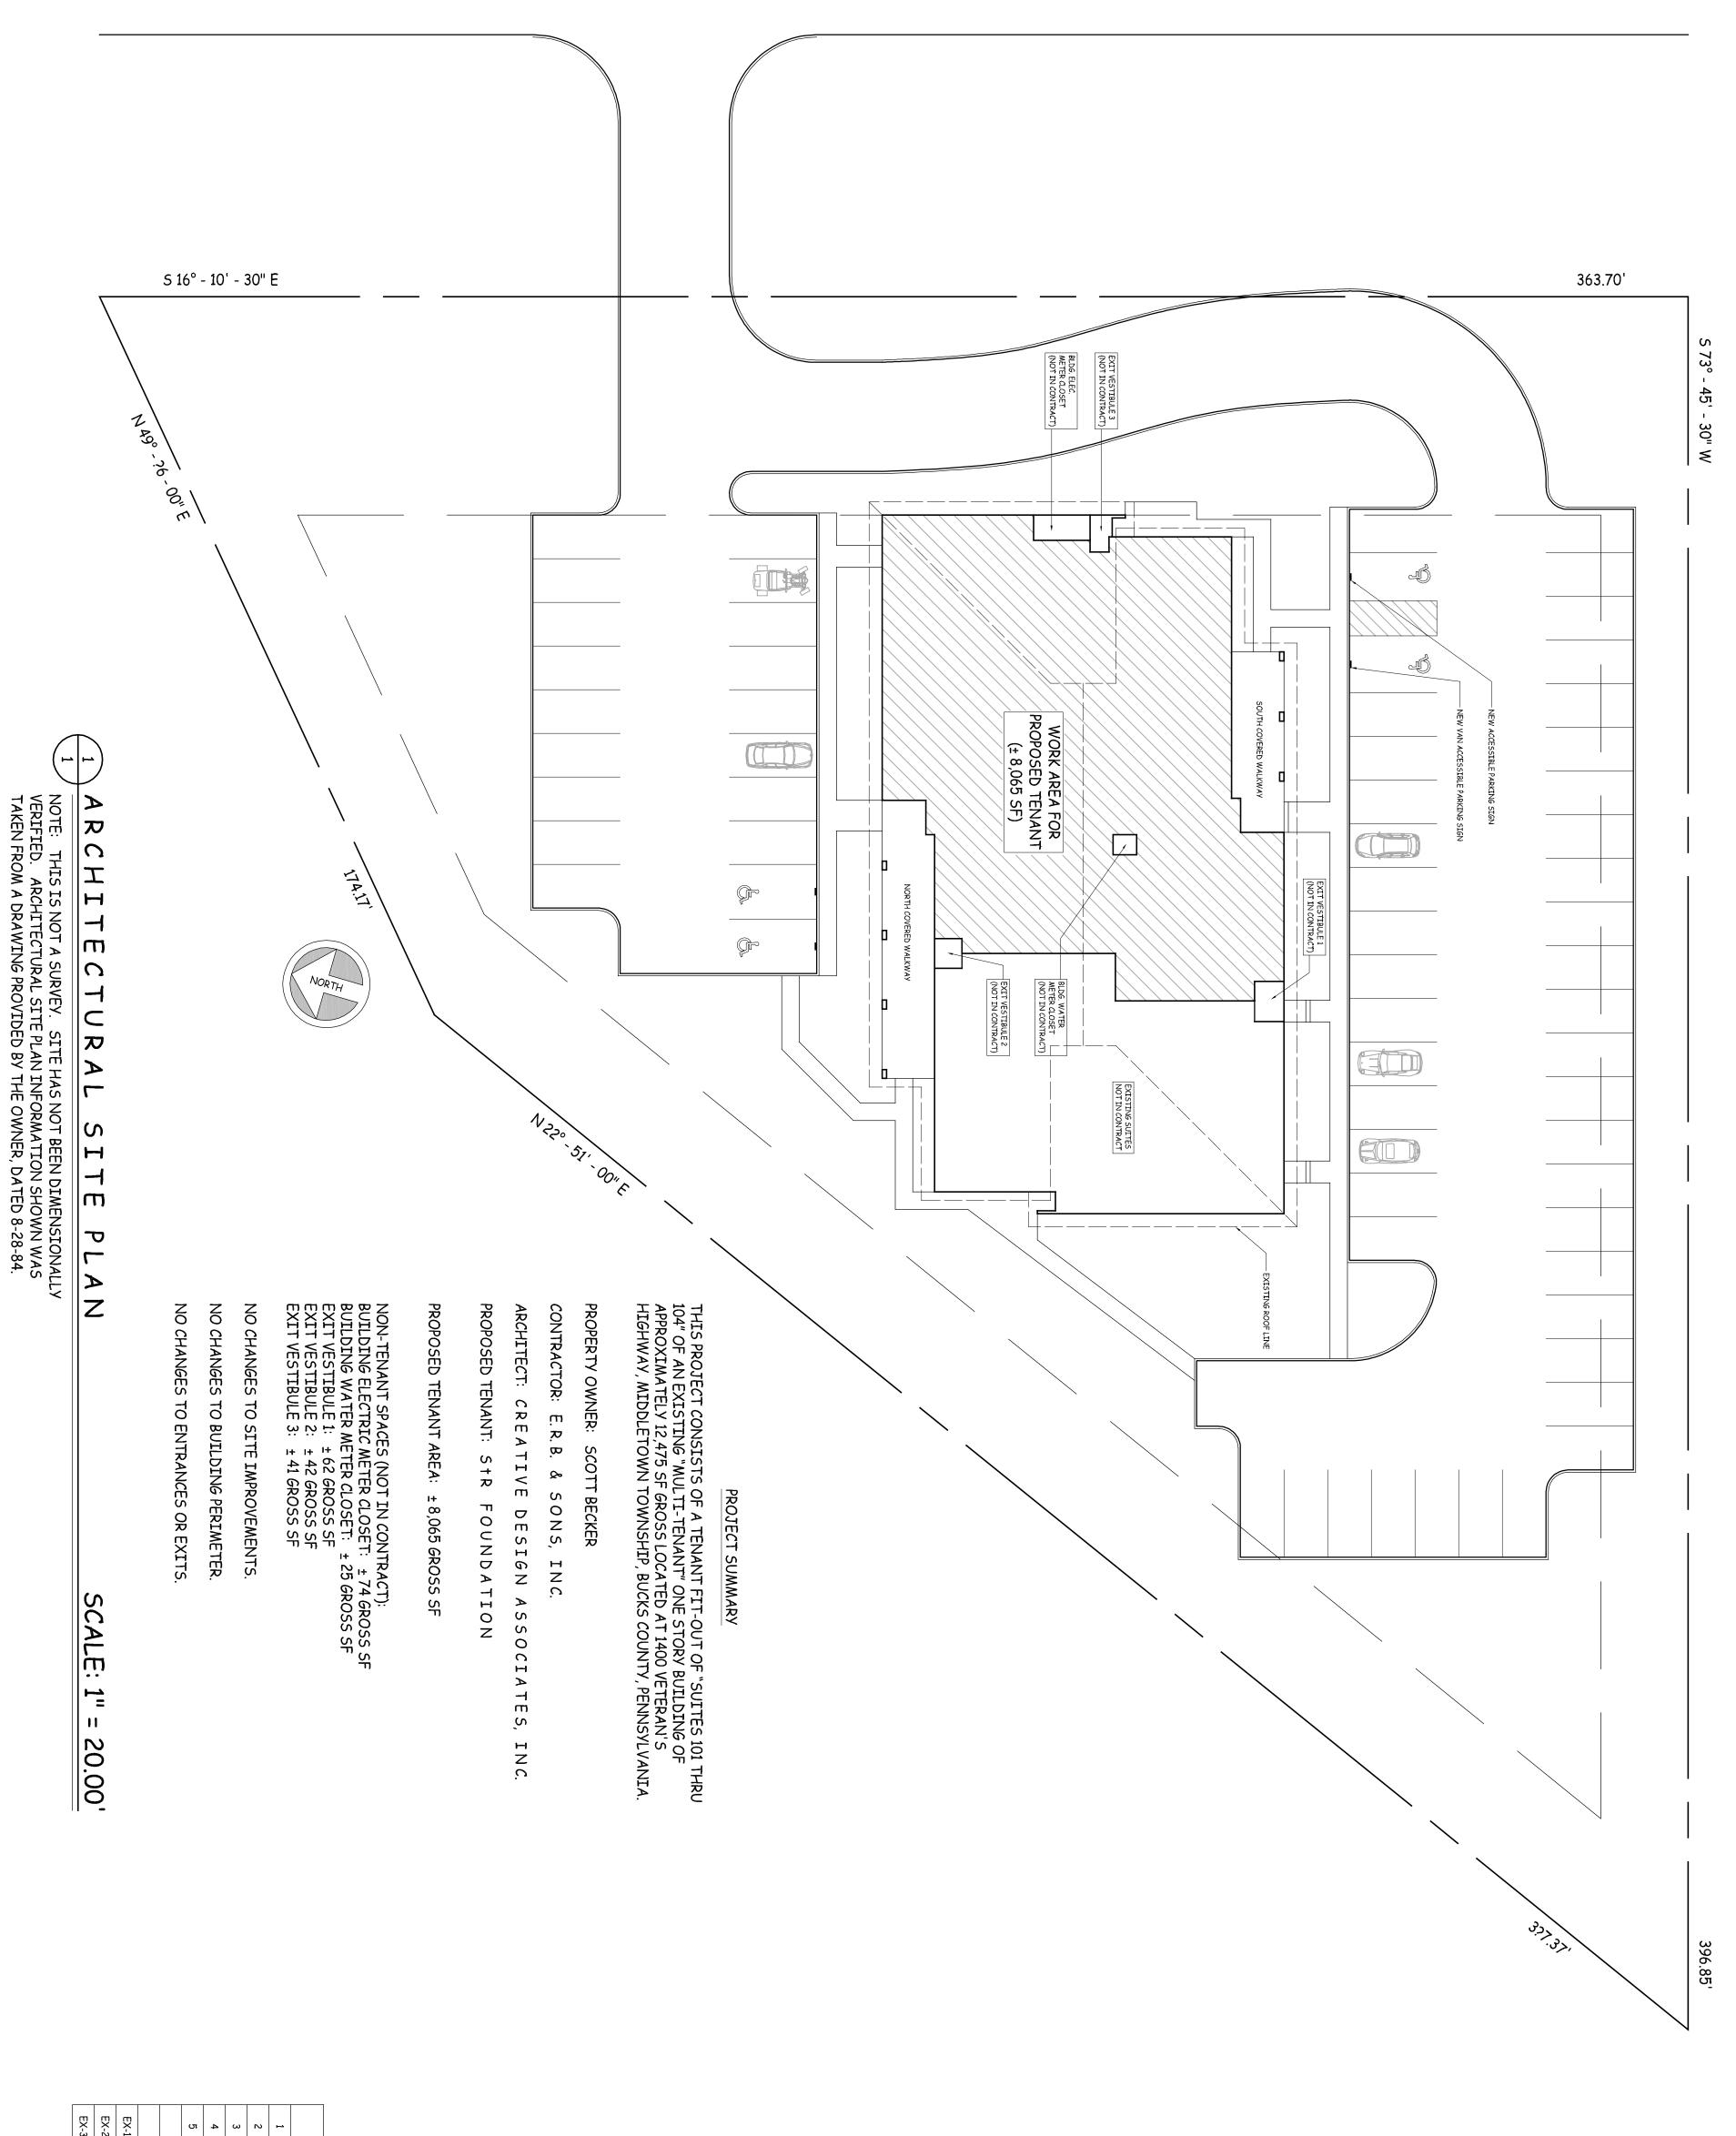

| EX-3 | EX-2 | EX-1 | - A7 | Cī | 4 | ω | 2 | 1 | |
|--------------------------|---------------------------------|---------------------|------------------------------|----------------------|--------------------------------|-------------------------------------------------|---------------------|-------------------------|------------------|
| EXISTING ELECTRICAL PLAN | EXISTING REFLECTED CEILING PLAN | EXISTING FLOOR PLAN | REFERENCE DRAWINGS AVAILABLE | ACCESSIBLE RESTROOMS | FINISH SCHEDULE AND CODE NOTES | PROPOSED REFLECTED CEILING AND ELECTRICAL PLAN | PROPOSED FLOOR PLAN | ARCHITECTURAL SITE PLAN | LIST OF DRAWINGS |

| Comm. No. 13 - 2982 | | Sheet No. |
|------------------------|---------|-----------|
| of 5 | | • |

ARCHITECTURAL SITE PLAN MIDDLETOWN PROFESSIONAL PLAZA 1400 VETERANS HIGHWAY LEVITTOWN, PA 19047 MIDDLETOWN TWP., BUCKS CO., PENNA.

TENANT FIT-OUT FOR: STR FOUNDATION

| | Gene Bauerle, G.C. PA Contractor #083365 |
|----------------------------------------------|------------------------------------------|
| E. R. B. & | Sons, Inc. |
| GENERAL C | ONTRACTING |
| 1117 Eagle Road Huntingdon Valley, PA 190 | 267-228-7451 06 erbjr@comcast.net |

| AN | PA Reg RA008011X - NJ Reg 21Al00908100 |
|------------------------|----------------------------------------|
| C reative D es | sign A ssoicates, Inc. |
| ARCHITECTURE INTERIORS | S SITE & SPACE PLANNING |

| VALI IMPR SEAL SIGN | REV. | # REVISION DESCRIPTION | DATE |
|------------------------------------|------|--------------------------------------------------|-------------|
| VALID IMPRE: SEAL A SIGNA | | PROJECT START-UP, BUILDING VERIFICATION | 7 / 30 / 20 |
| | | PER OWNER / TENANT / CONTRACTOR / ARCHITECT MTG. | 8 / 13 / 20 |
| $\sigma \circ \sigma$ | | PER OWNER / TENANT / CONTRACTOR / ARCHITECT MTG. | 8 / 26 / 20 |
| PERMI WITH DRIGIN | | FOR CONSTRUCTION | 9/5/20 |
| AITS TH OF TNAL "RED" | | | |
| , SIGIN ONLY | | | |
| S ONLY IF D" | | | |
| AL IF | | | |